


Church wall

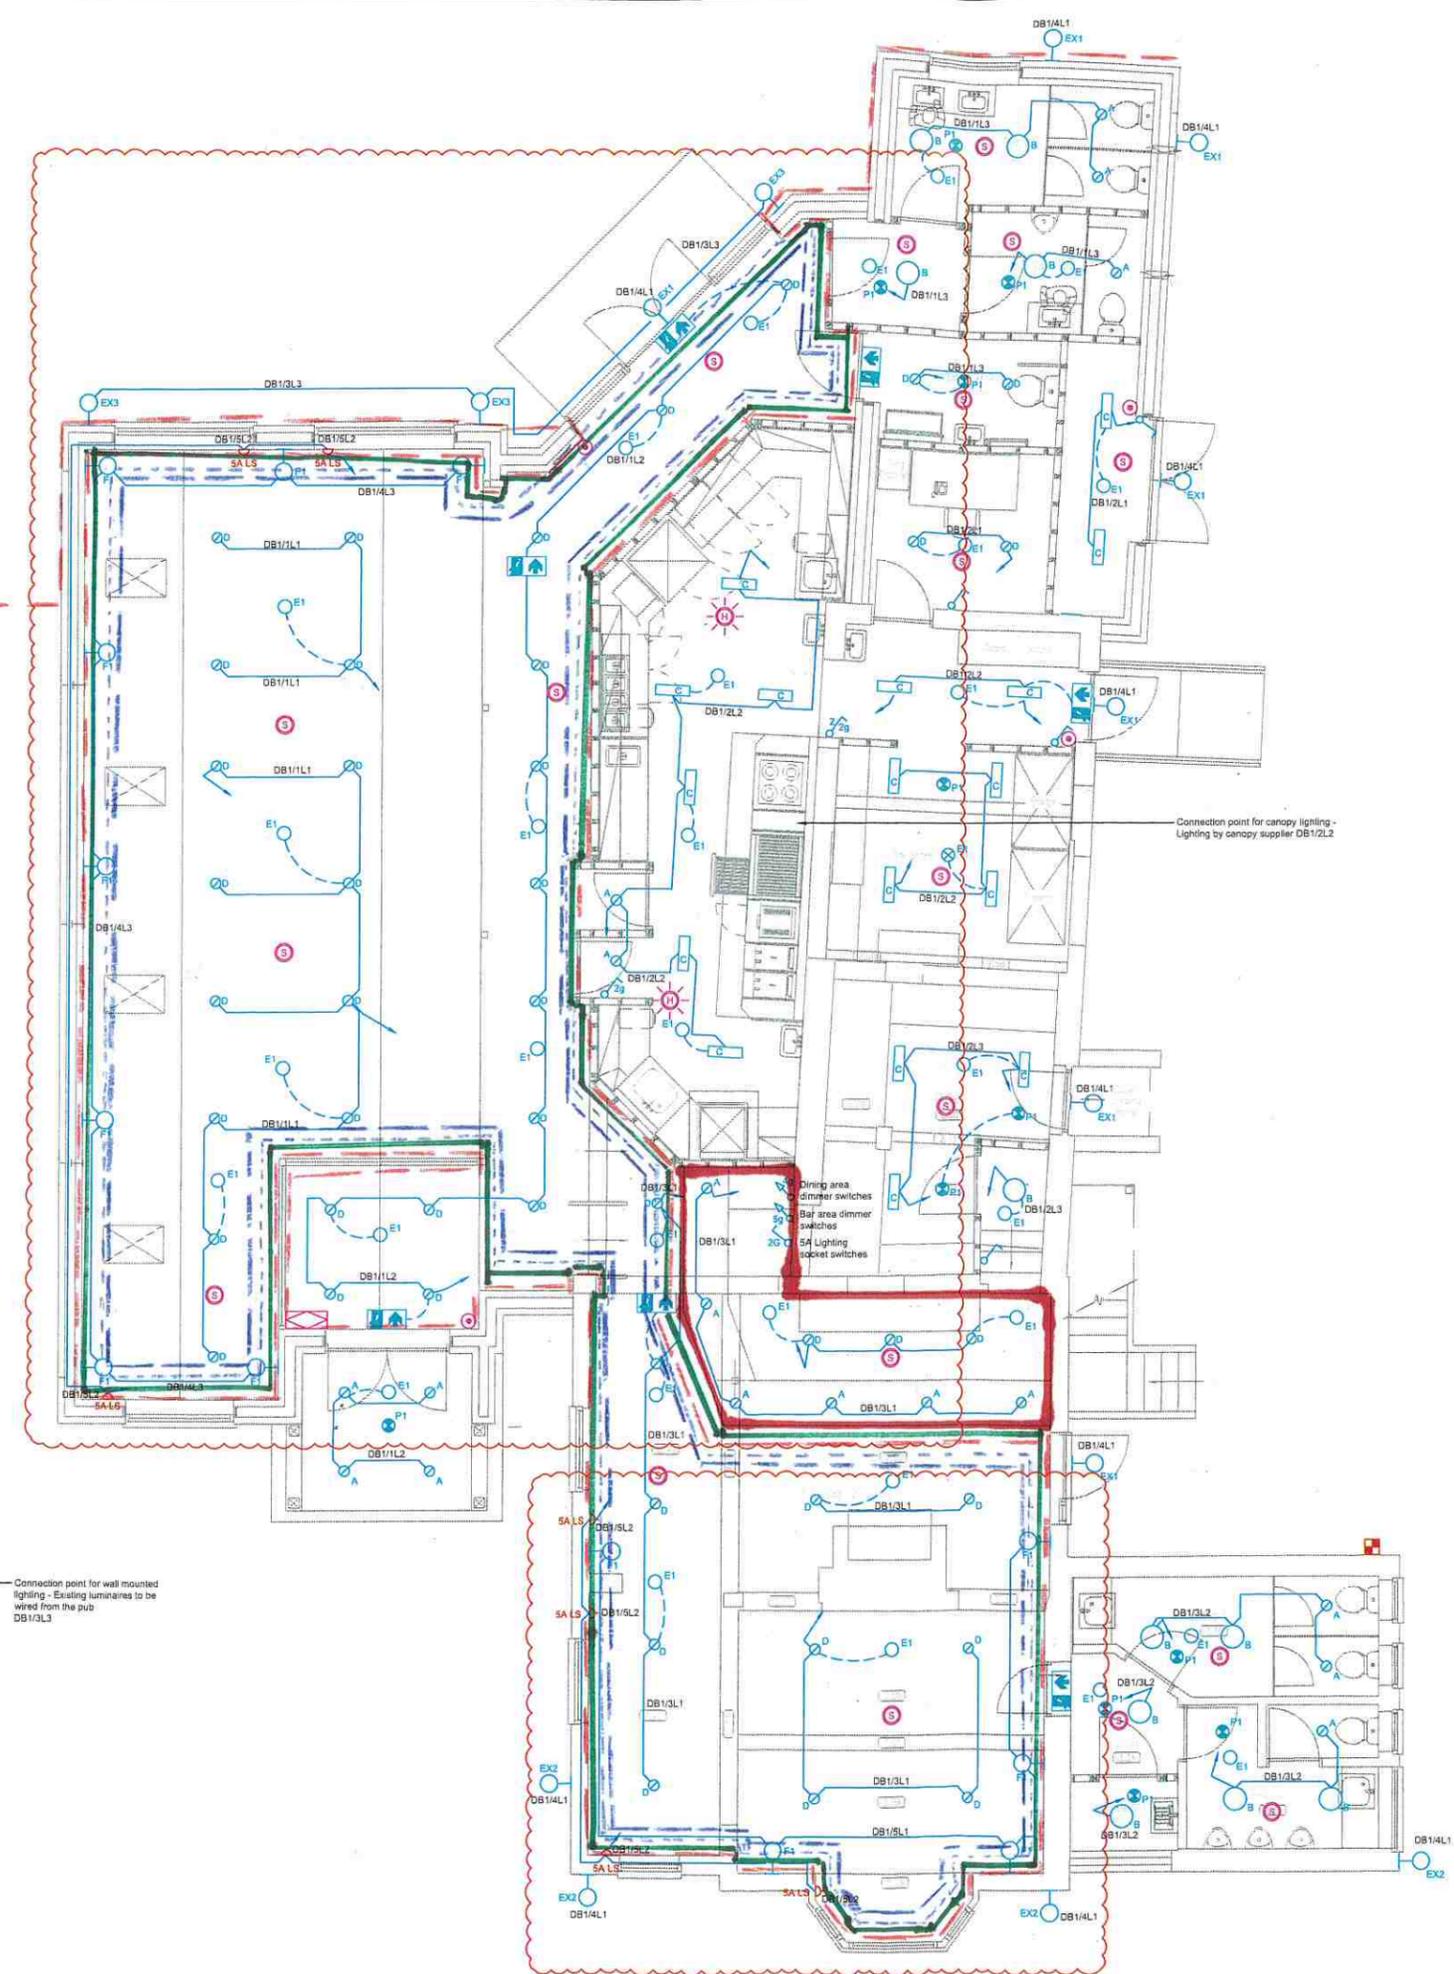

Connection point for canopy lighting - Lighting by canopy supplier DB1/2L2

Connection point for wall mounted lighting - Existing luminaires to be wired from the pub DB1/3L3

**Legend:**

- Surface mounted round luminaire
- Wall mounted luminaire
- Recessed LED downlighter
- Surface mounted LED emergency luminaire
- Internally illuminated exit sign
- Surface mounted LED linear luminaire
- Lighting switch one way (n=no of gangs)
- Dimmer switch
- 230V PIR movement detector
- Fire alarm control panel
- Smoke detector with sounder base
- Heat detector with sounder base and beacon
- Break glass unit
- Contactor
- SA Lighting Socket
- Typical Switch Line
- Typical Circuit Line
- Typical Circuit Link

**Handwritten Notes:**

- SALE OF ALCOHOL
- CONSUMPTION OF ALCOHOL
- INDOOR SPORTING EVENTS
- RECORD & MUSIC
- LIVE MUSIC

P02	Client's comments incorporated	PG	AH	09.25
P01	Preliminary Issue	PG	DF	07.25
Rev	Description	Drawn	Chk'd	Date

Client:

Project:  
Elmswell Tavern

Drawing Title:  
Lighting & Fire Alarm Layout  
Ground Floor  
*ALCOHOL APPLICATION*

Drawing Ref: 906000-JSH-ZZ-00-DR- E - 0900 Rev: P02

Status: S2 - Preliminary Scale: A1 @ 1:50